

September 17, 2012

CITY OF MILWAUKEE
DEPARTMENT OF PUBLIC WORKS
MILWAUKEE WATER WORKS

ADDENDUM NO. 1

The purpose of this addendum is to provide updated information to supersede and change the following sections of the specifications for HP-178.

1. **JOB REQUIREMENTS**, JR-11 START AND COMPLETION DATE:

REMOVE “Work on this project shall be complete by Friday, November 16, 2012.”


INSERT “After the Notice to Proceed is issued, 50% of the work shall be completed within 30 work days and 100% of the work shall be completed within 60 work days. Days where no work occurs due to inclement weather or reasonable cause will not be counted towards the total work days. Work shall be suspended for the winter by November 16, 2012. If the weather after November 16, 2012 is conducive to the scheduled work, the Contractor will be permitted to continue said work. The Contractor, Roofing System Manufacturer and City shall mutually agree upon whether work will continue past November 16, 2012.”

2. **CONTRACT DRAWINGS**:


REMOVE HP-178-03

INSERT HP-178-03R

END OF ADDENDUM NO. 1

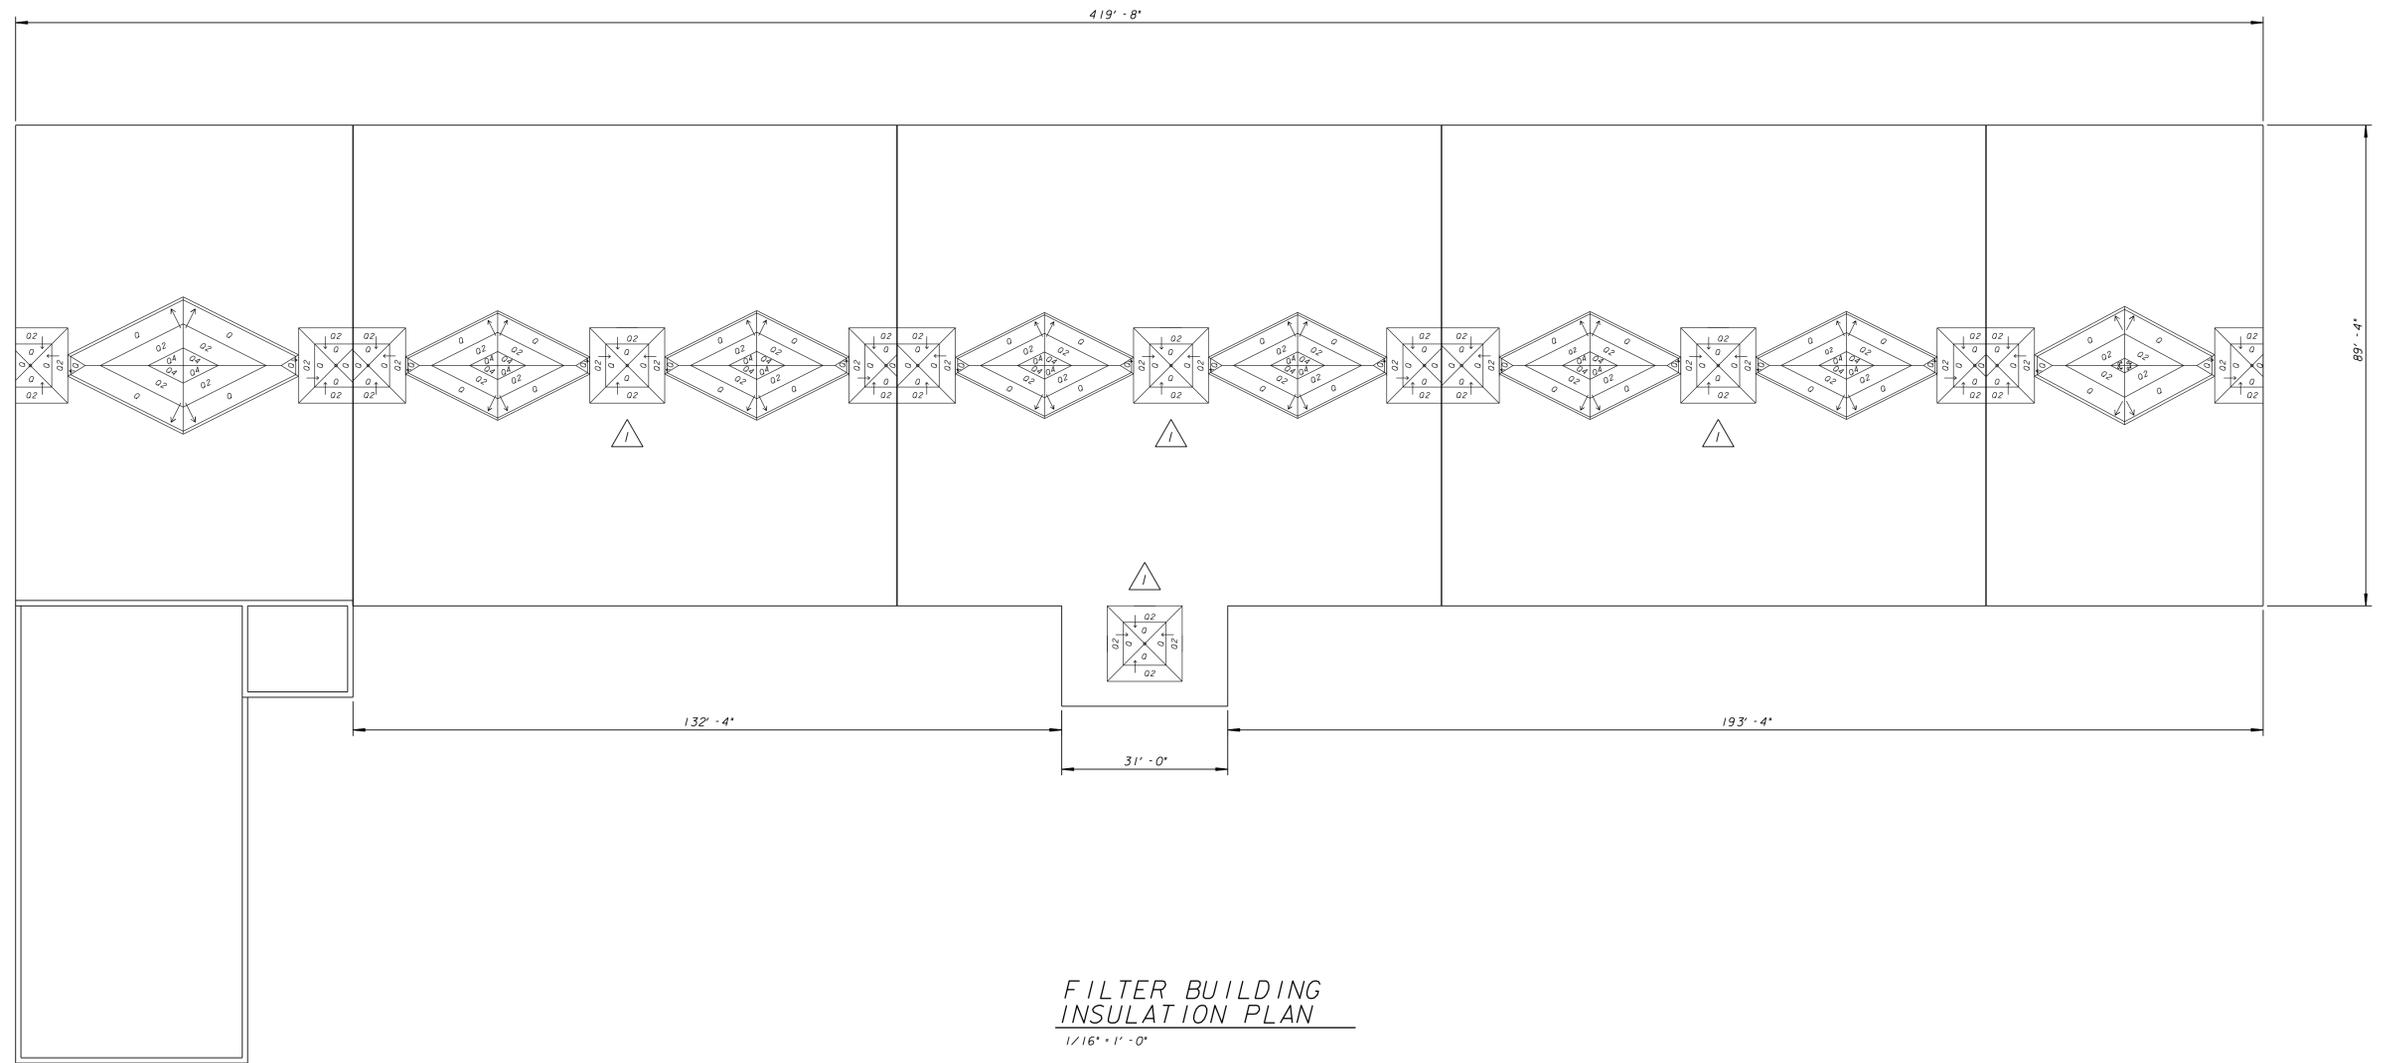


FILTER BUILDING
INSULATION PLAN
1/16" = 1' - 0"

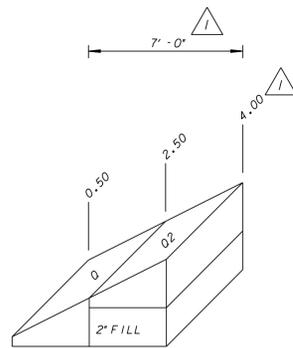

TAPERED SUMP SECTION
Q, Q2
NOT TO SCALE

1/2" x 6" TAPERED EDGE TO
BE FURNISHED AND INSTALLED
BY THE CONTRACTOR

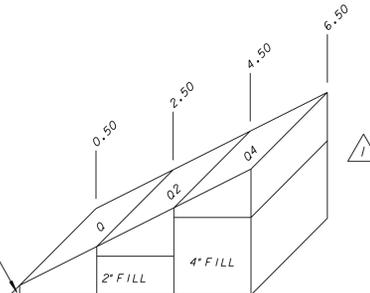

TAPERED SADDLE SECTION
Q, Q2, Q4, Q6, Q8
NOT TO SCALE

NOTES:

1. TAPERED SUMP SLOPE = 1/2" / FT.
2. CRICKET SLOPE = 1/2" / FT. MINIMUM.
3. ELEVATIONS SHOWN DO NOT INCLUDE AN OVERLAY BOARD.
4. CONTRACTOR TO FURNISH AND INSTALL CRICKETS AT THE HIGH SIDES OF ALL ROOF PENETRATIONS IF NOT SHOWN ON THE ROOF PLAN.
5. TAPERED SUMP AREA = 1,347 SQ. FT.

Milwaukee Water Works Department of Public Works
Water Engineering
WATER PURIFICATION PLANT
FILTER BUILDING ROOF REPLACEMENT
INSULATION PLAN

DESIGNED BY	M.A.G.	APPROVED	DATE
DRAWN BY	S. MILLER	<i>Mark Kramer</i>	9-14-12 PLANTS PROJECT ENGINEER
CHECKED BY		<i>Susan B. Hart</i>	9-14-12 CHIEF DESIGN ENGINEER
DATE	7-16-2012	<i>Culleers</i>	9-14-12 SPECIAL DEPUTY COMMISSIONER OF PUBLIC WORKS
SCALE	AS SHOWN		
WORK ORDER		OFFICIAL NOTICE	99-2012
NO.	BY	REVISION	DATE
			FILE NO. B-12-2

DRAWING NO. HP-178-03R